

LEGEND:

SYMBOL	DESIGNATION
(A)	AMMETER
AS	AMMETER CHANGE OVER SWITCH
(V)	VOLT METER
VS	VOLT METER CHANGE OVER SWITCH
VCB	VACUUM CIRCUIT BREAKER (DRAWABLE TYPE)
MCCB	MOULDED CASE CIRCUIT BREAKER
MCB	MINIATURE CIRCUIT BREAKER
RCBO	RESIDUAL CURRENT CIRCUIT BREAKER WITH OVERCURRENT PROTECTION
FUSE SW	FUSE SWITCH
Cx	CONTACT OF CONTACTOR
FUSE UNIT	FUSE UNIT
(L1-L3)	INDICATING LIGHT
Subdistribution Board	SUBDISTRIBUTION BOARD
⊕	EARTH
DOL	DIRECT ONLINE STARTER

- NOTES:**
- ALL DIMENSIONS ARE IN MILLIMETER UNLESS NOTED OTHERWISE.
 - ALL LEVELS ARE IN METERS RELATIVE TO CHART DATUM (CD), BASED ON BATHYMETRIC SURVEY 0705/DRW/01-BAT/REV. 1 BY PETRO SEIS SDN. BHD.

LAND OWNER :

SABAH PORTS AUTHORITY
SPA Head Office Building,
Jalan Tun Fuad, Tanjung Lipat,
Locked Bag 2005,
88617 Kota Kinabalu,
Sabah, East Malaysia
Tel : + 6088-538400
Fax : + 6088-223038

CLIENT :

SABAH PORTS SDN. BHD.
SPSB Headquarters & Operation Building,
Sapangar Bay,
89450 Kota Kinabalu,
Sabah, East Malaysia
Tel : + 6088-483390
Fax : + 6088-489921

PROJECT MANAGEMENT CONSULTANT:

SCHB ENGINEERING SERVICES SDN. BHD.
4th Floor, Wisma Perkasia,
Jalan Gaya,
88521 Kota Kinabalu,
Sabah, Malaysia
Tel : + 6088-235787

REV	DATE	DESCRIPTION	BY	CHK	APP
03	20/12/18	ADDED GENERATOR	JAS	TSW	AW
02	25/10/18	FOR COMMENTS	JAS	TSW	AW
01	06/06/17	FOR COMMENTS	JAS	TSW	AW
00	28/03/17	FOR COMMENTS	JAS	TSW	AW

PROJECT :

PROPOSED JETTY EXTENSION OF SAPANGAR BAY OIL TERMINAL

TITLE :

DISTRIBUTION BOARD SINGLE LINE DIAGRAM








CONSULTANT :

PERUNDING KINAKATA SDN. BHD.
(No. Syarikat 319584)
3rd Floor, Lot 12 & 13, Block C,
Damansara Plaza II, Jalan Damansara,
60000 Kuala Lumpur
P.O. Box 20136, 88758 Luyang
Kota Kinabalu, Sabah
Tel : + 6088-258133 FAX : 088-260133
Email : jkb@kinakata.com

IN ASSOCIATION WITH :

HaskoningDHV Sdn Bhd
(Company No. 334829A)
UNIT 55&6, CIVIL DAMANSARA
No. 685, JALAN DAMANSARA
TAMAN TUN DR. ISMAIL
60000 KUALA LUMPUR
+60 (0) 3 7733 7003 Telephone
+60 (0) 3 7733 7023 Fax
haskoningdhv.com.my E-mail
www.haskoningdhv.com Website

DRAWN : JAS	CHECKED : TSW	PASSED : AW
DATE : 20.12.2018	CLIENT'S REF. : 1M0341	
SCALE AT A1 : AS SHOWN	AUTOCAD REF. : 1M0341-E-101_R03.dwg	
DRAWING No.	REVISION	

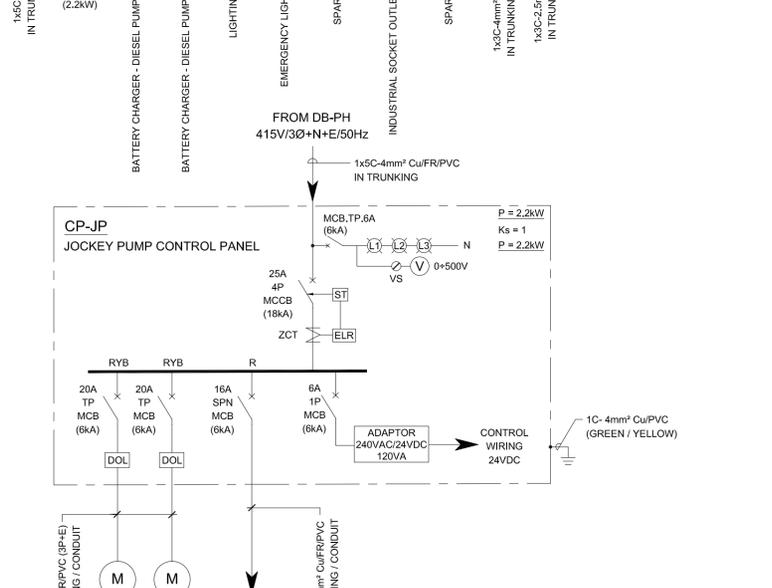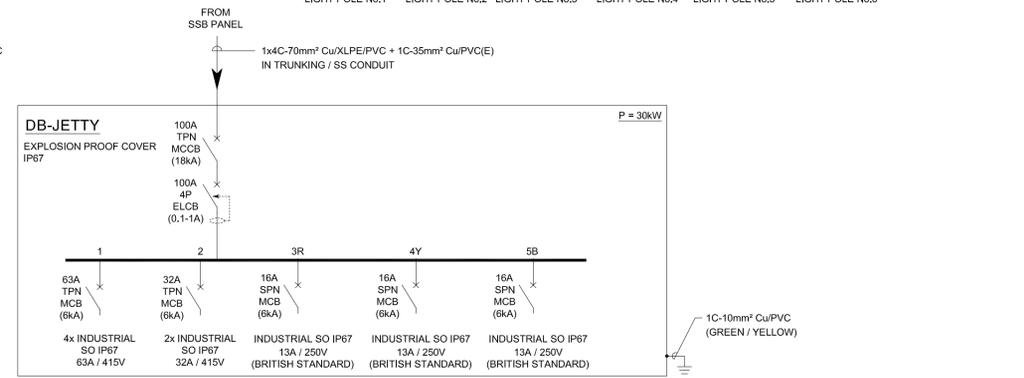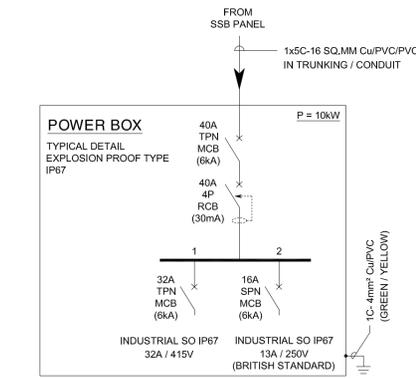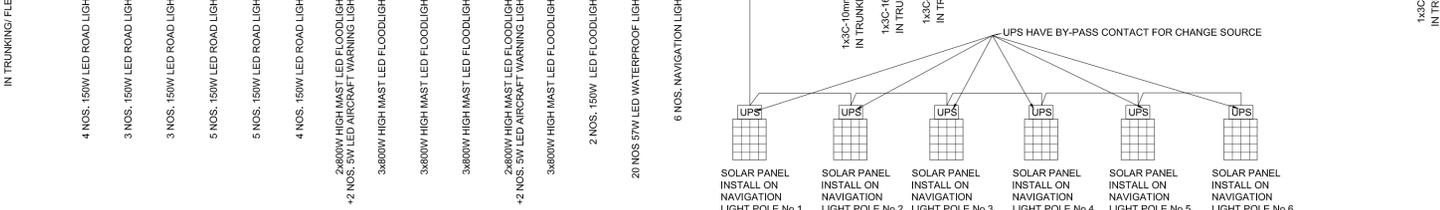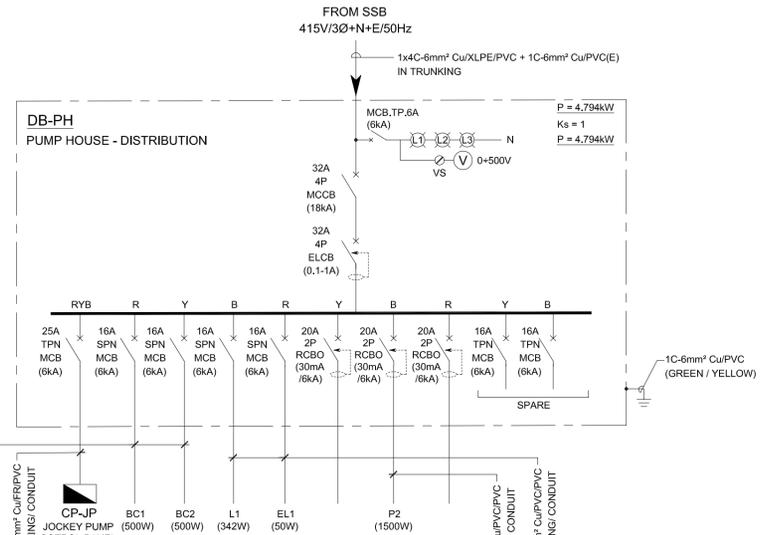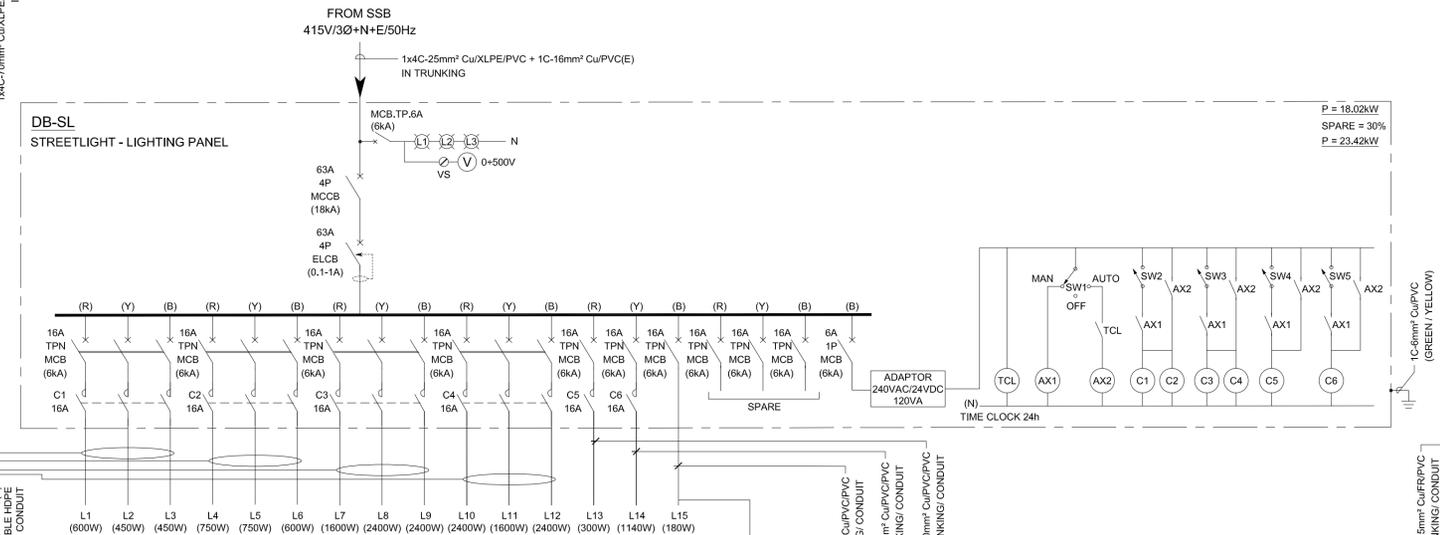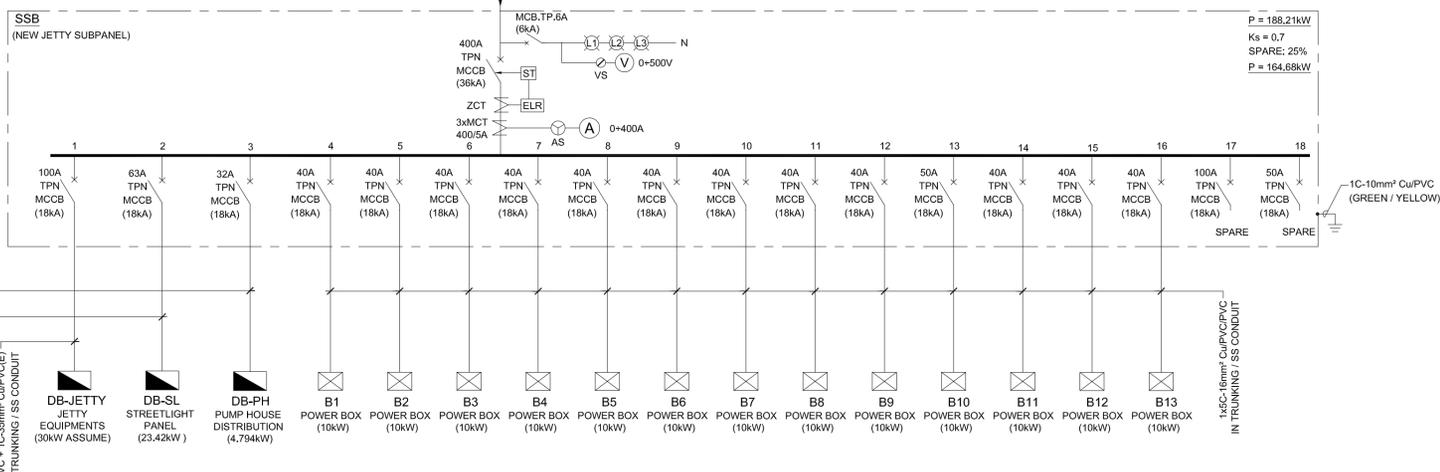

This drawing is issued under Terms of Appointment/Agreement detailing copyright. © HaskoningDHV Sdn. Bhd.